

AECOM

PROJECT

**TUEN MUN -
CHEK LAP KOK LINK**

**CONTRACT TITLE
TUEN MUN - CHEK LAP KOK LINK
- SOUTHERN CONNECTION
VIADUCT SECTION**

CONSULTANT

AECOM Asia Company Ltd
www.aecom.com

SUB-CONSULTANT

Figure 1.2a

ISSUE/REVISION SMT			
A	NOV. 12	TENDER ADDENDUM NO. 1	CWN
-	OCT. 12	TENDER DRAWING	CWN
MR.	DATE MM/DD/YR	DESCRIPTION	CHK.

STATUS

SCALE **DIMENSION UNIT**
比例 尺寸单位
1:1000 METRES

KEY PLAY

PROJECT NO. **CONTRACT NO.**

60240249 HY/2012/07

SOUTHERN CONNECTION
GENERAL LAYOUT PLAN


SHEET NUMBER

60240249/C1/2000A



Rev	Description	By	Date	Rev	Description	By	Date	Drawn	Date	Client	Project Title	Drawing title
A	SUBMISSION	RC	07/13					RL	07/13	路政署 HIGHWAYS DEPARTMENT 香港-珠海-深圳跨海大桥 香港项目管理办公室	Contract No. HY/2012/07 Tuen Mun - Chek Lap Kok Link Southern Connection Viaduct Section	
B	SUBMISSION	RC	07/13					Checked	Approved	AECOM		
C	SUBMISSION	RC	09/13					DIS	DOP	Gammon		
								Scale	1:1000 @ A1 / 1:2000 @ A3	ARUP		
											Drawing no. J3518/P/OAP/04/01100 Rev. C	

Figure 1.2b

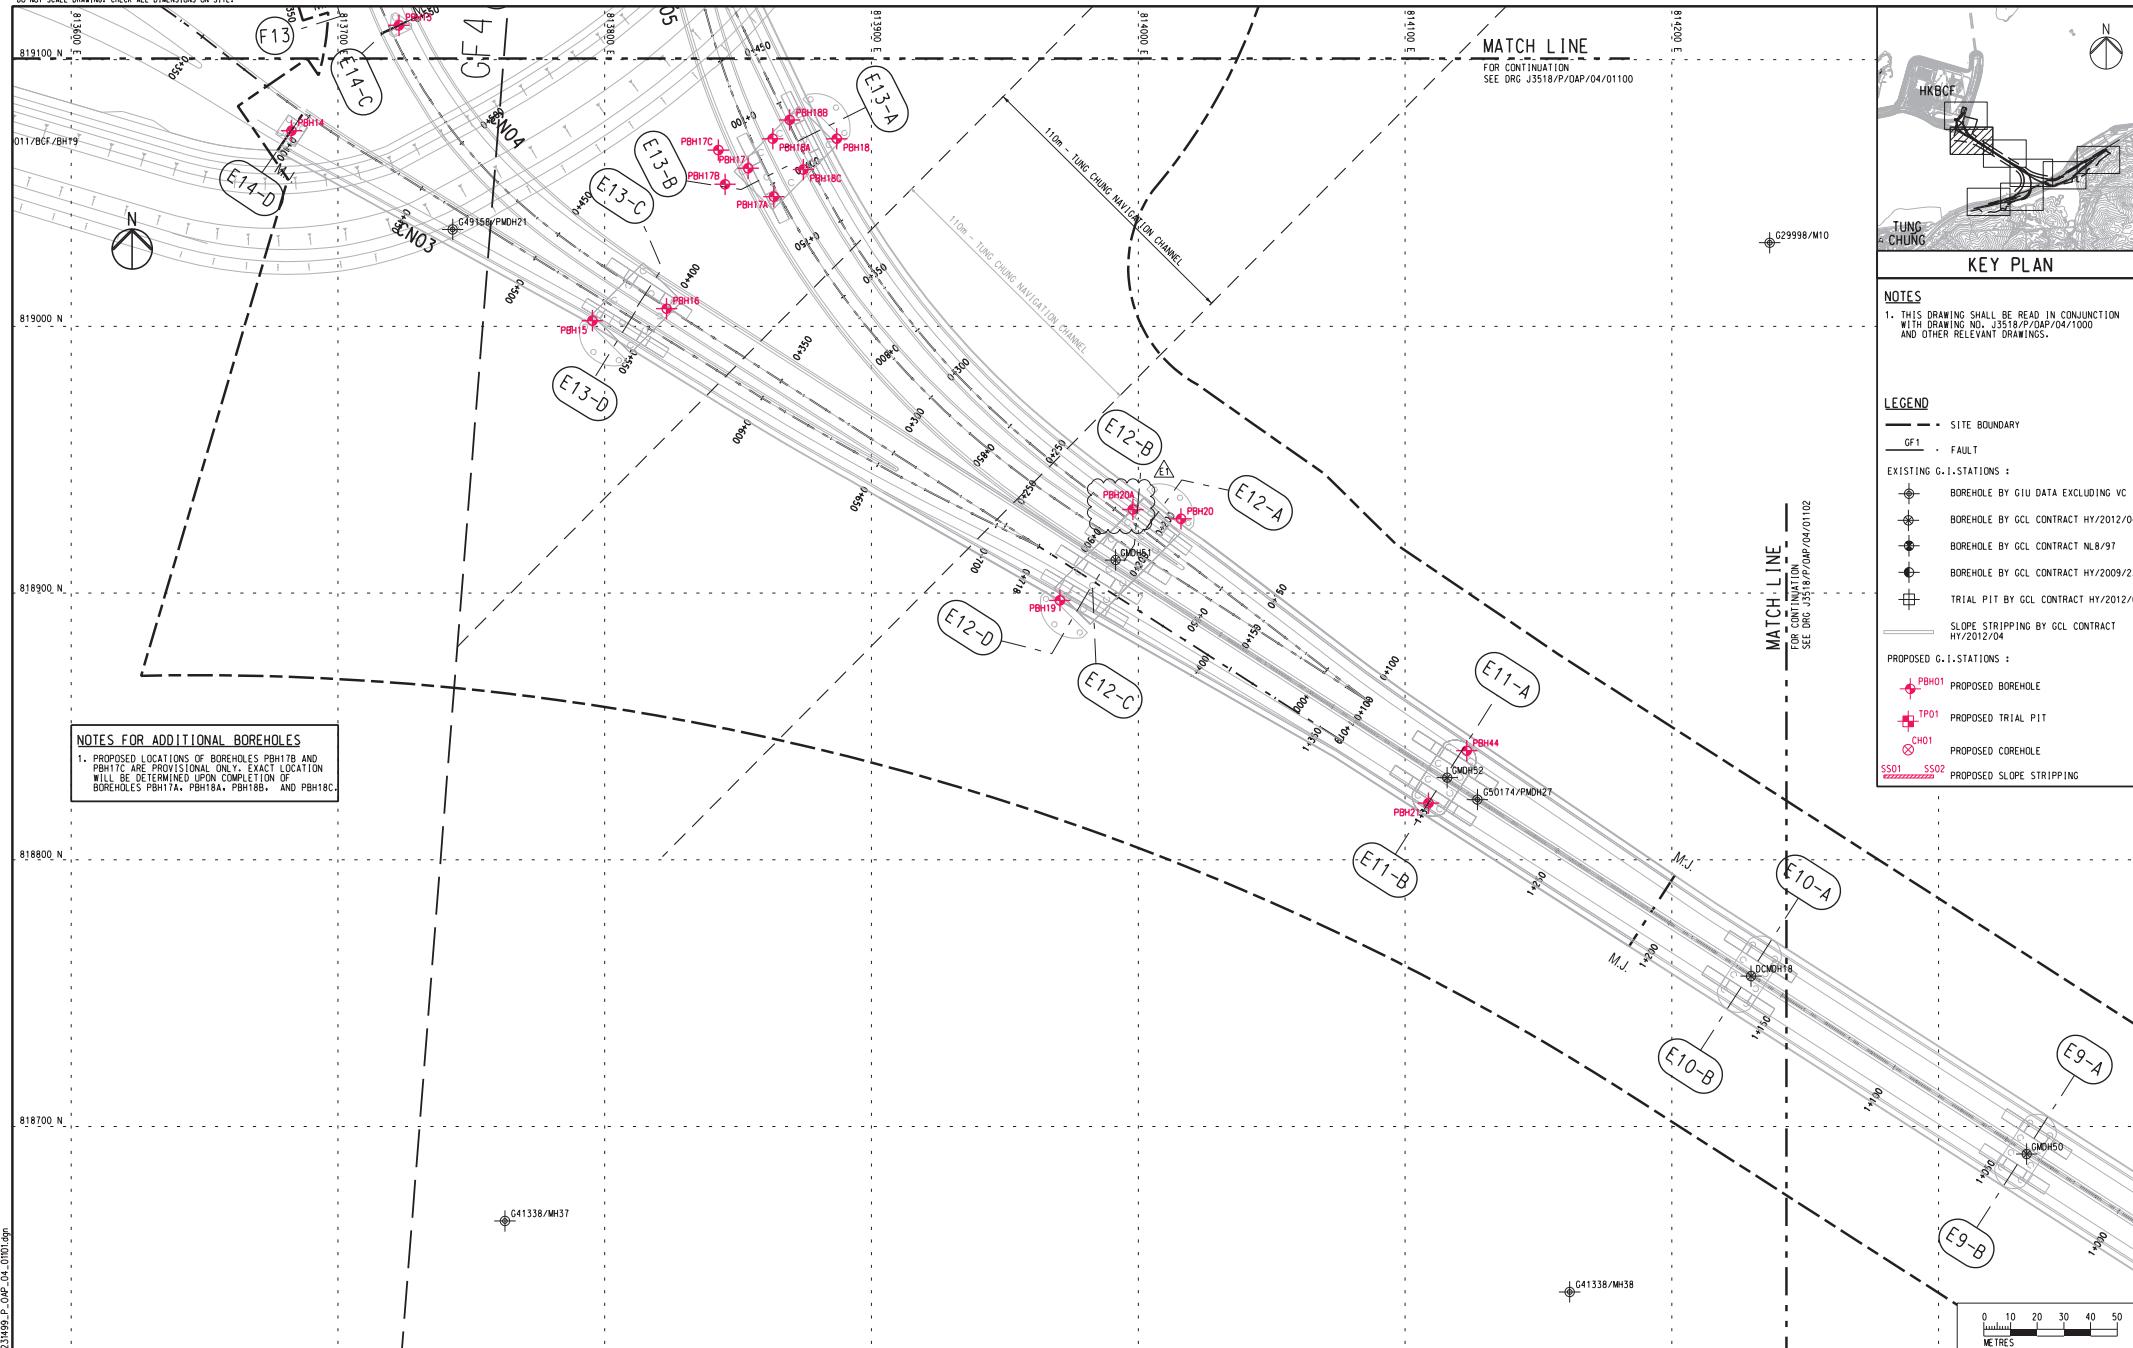


Rev	Description	By	Date	Rev	Description	By	Date
A	SUBMISSION	RC	07/13				
B	SUBMISSION	RC	07/13				
C	SUBMISSION	RC	07/13				
D	SUBMISSION	RC	10/13				
E1	FOR INTERNAL REVIEW	RC	11/13				

Drawn	Date	Client	Project Title
RL	07/13	HIGHWAYS DEPARTMENT 香港深水埗至青嶼幹線 Hong Kong-Zhuhai-Macao Bridge Hong Kong Project Management Office	Contract No. HY/2012/07 Tuen Mun - Chek Lap Kok Link Southern Connection Viaduct Section
Checked	Approved		
DS	DOP		
Scale	1:1000 @ A1 / 1:2000 @ A3	Supervising Officer	Contractor


AECOM

Gammon

ARUP

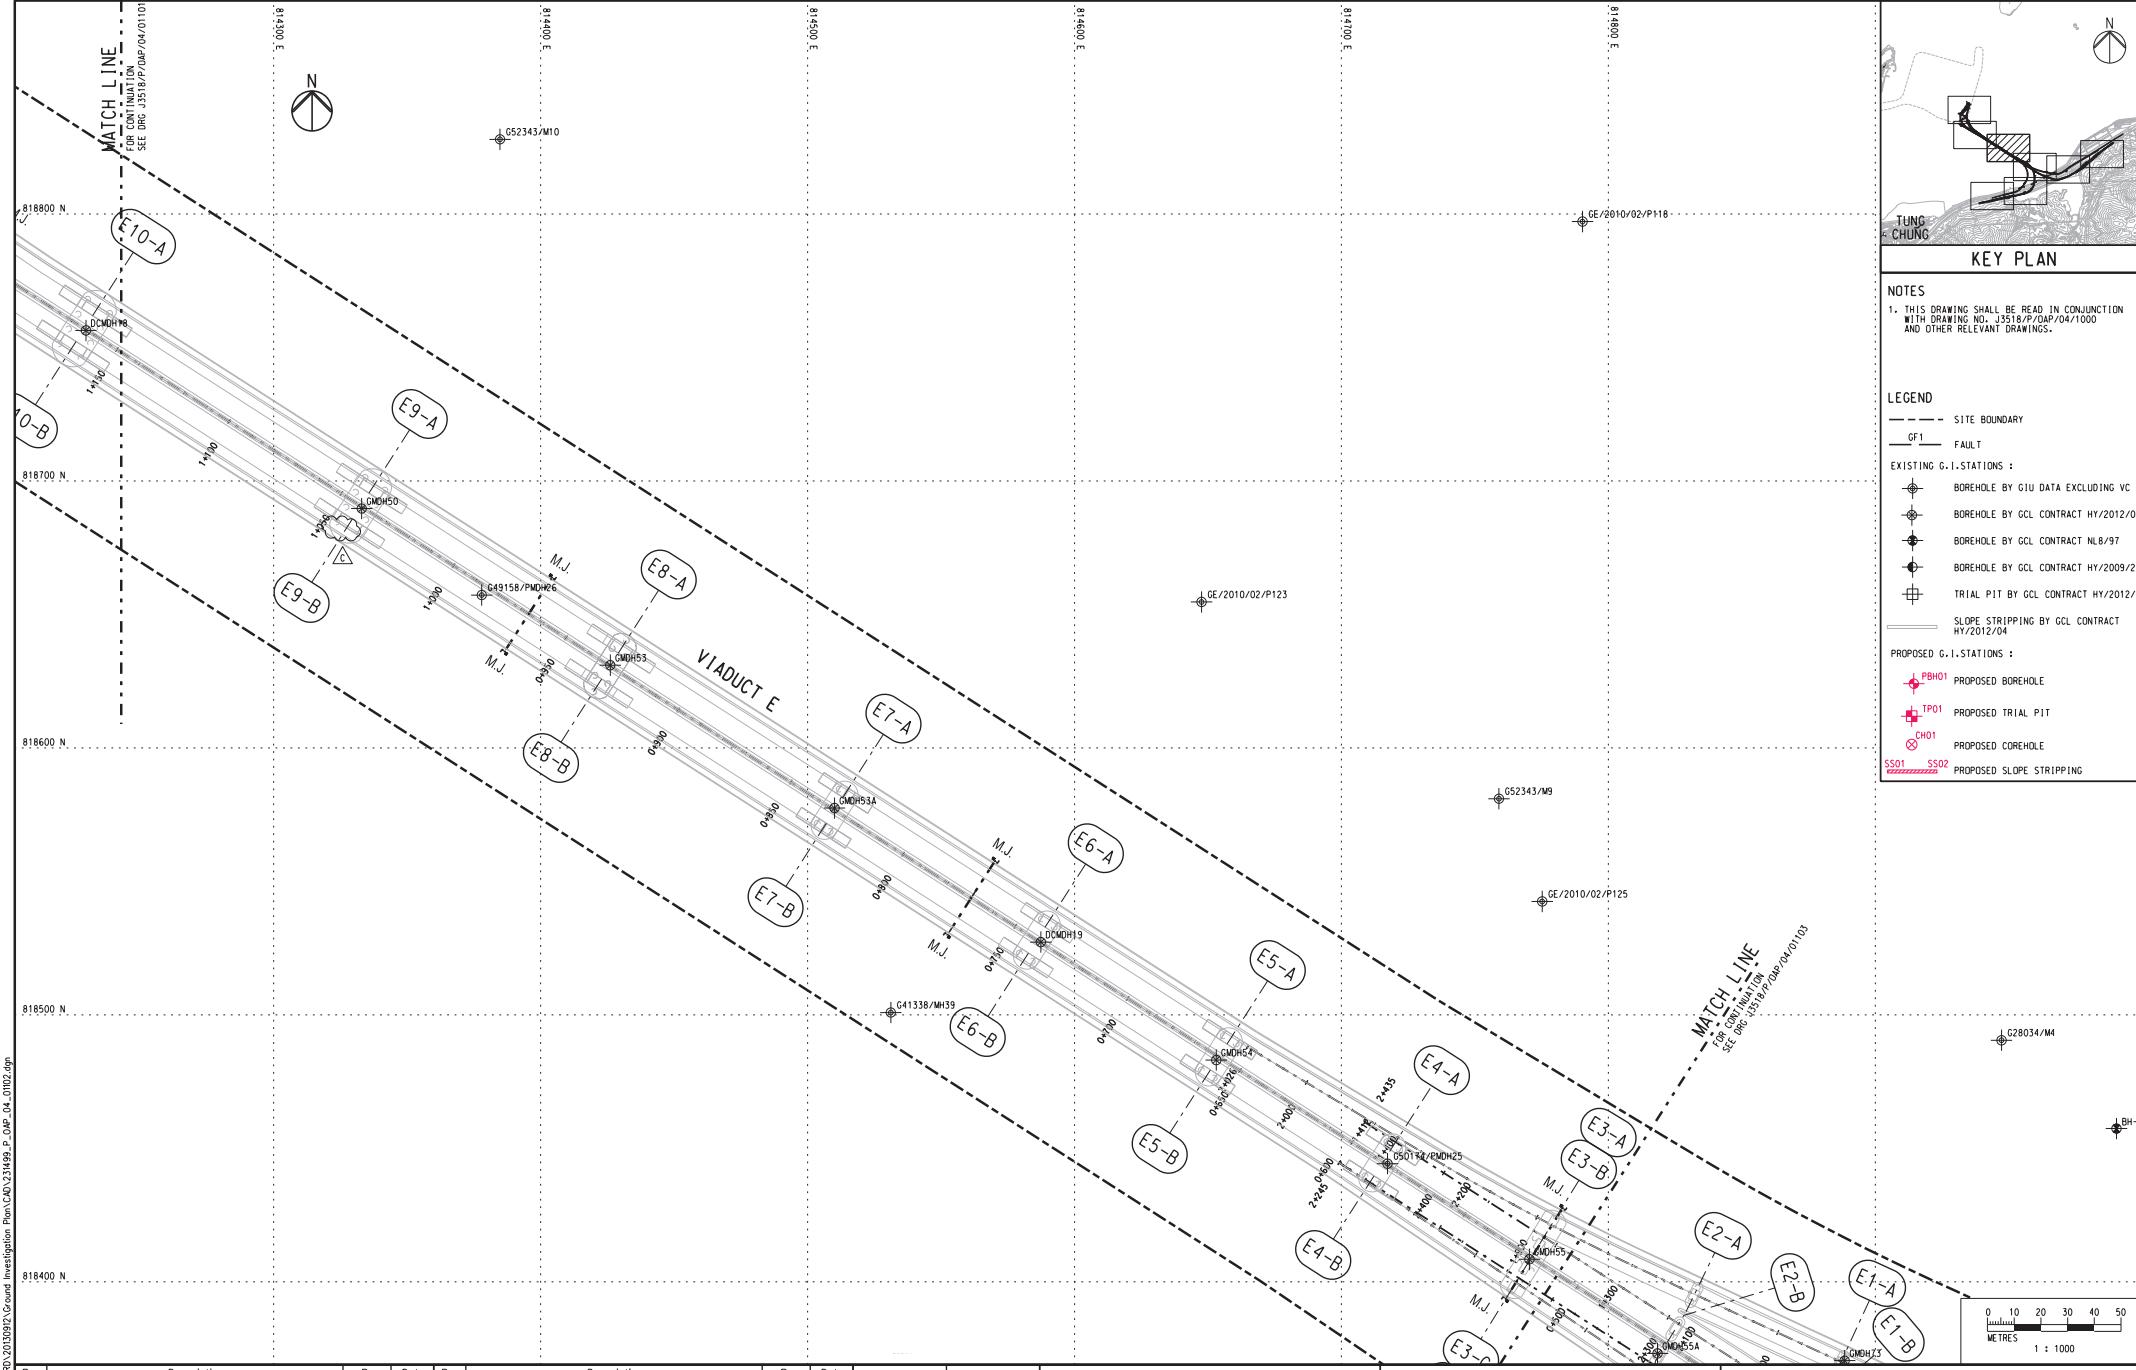

Rev	Description	By	Date	Rev	Description	By	Date	Drawn	Date	Client	Project Title	Drawing title
A	SUBMISSION	RC	07/13					RL	07/13	HIGHWAYS DEPARTMENT 路政署 港珠澳大桥香港工程管理处 Hong Kong-Zhuhai-Macau Bridge Project Management Office	Contract No. HY/2012/07 Tuen Mun - Chek Lap Kok Link Southern Connection Viaduct Section	Figure 1.2d
B	SUBMISSION	RC	07/13					Checked	Approved			
C	SUBMISSION	RC	09/13					DS	DOP			
								Scale	1:1000 @ A1 / 1:2000 @ A3	Supervising Officer	Contractor	Originator
										AECOM	Gammon	ARUP
												Drawing no. J3518/P/OAP/04/0102 Rev. C

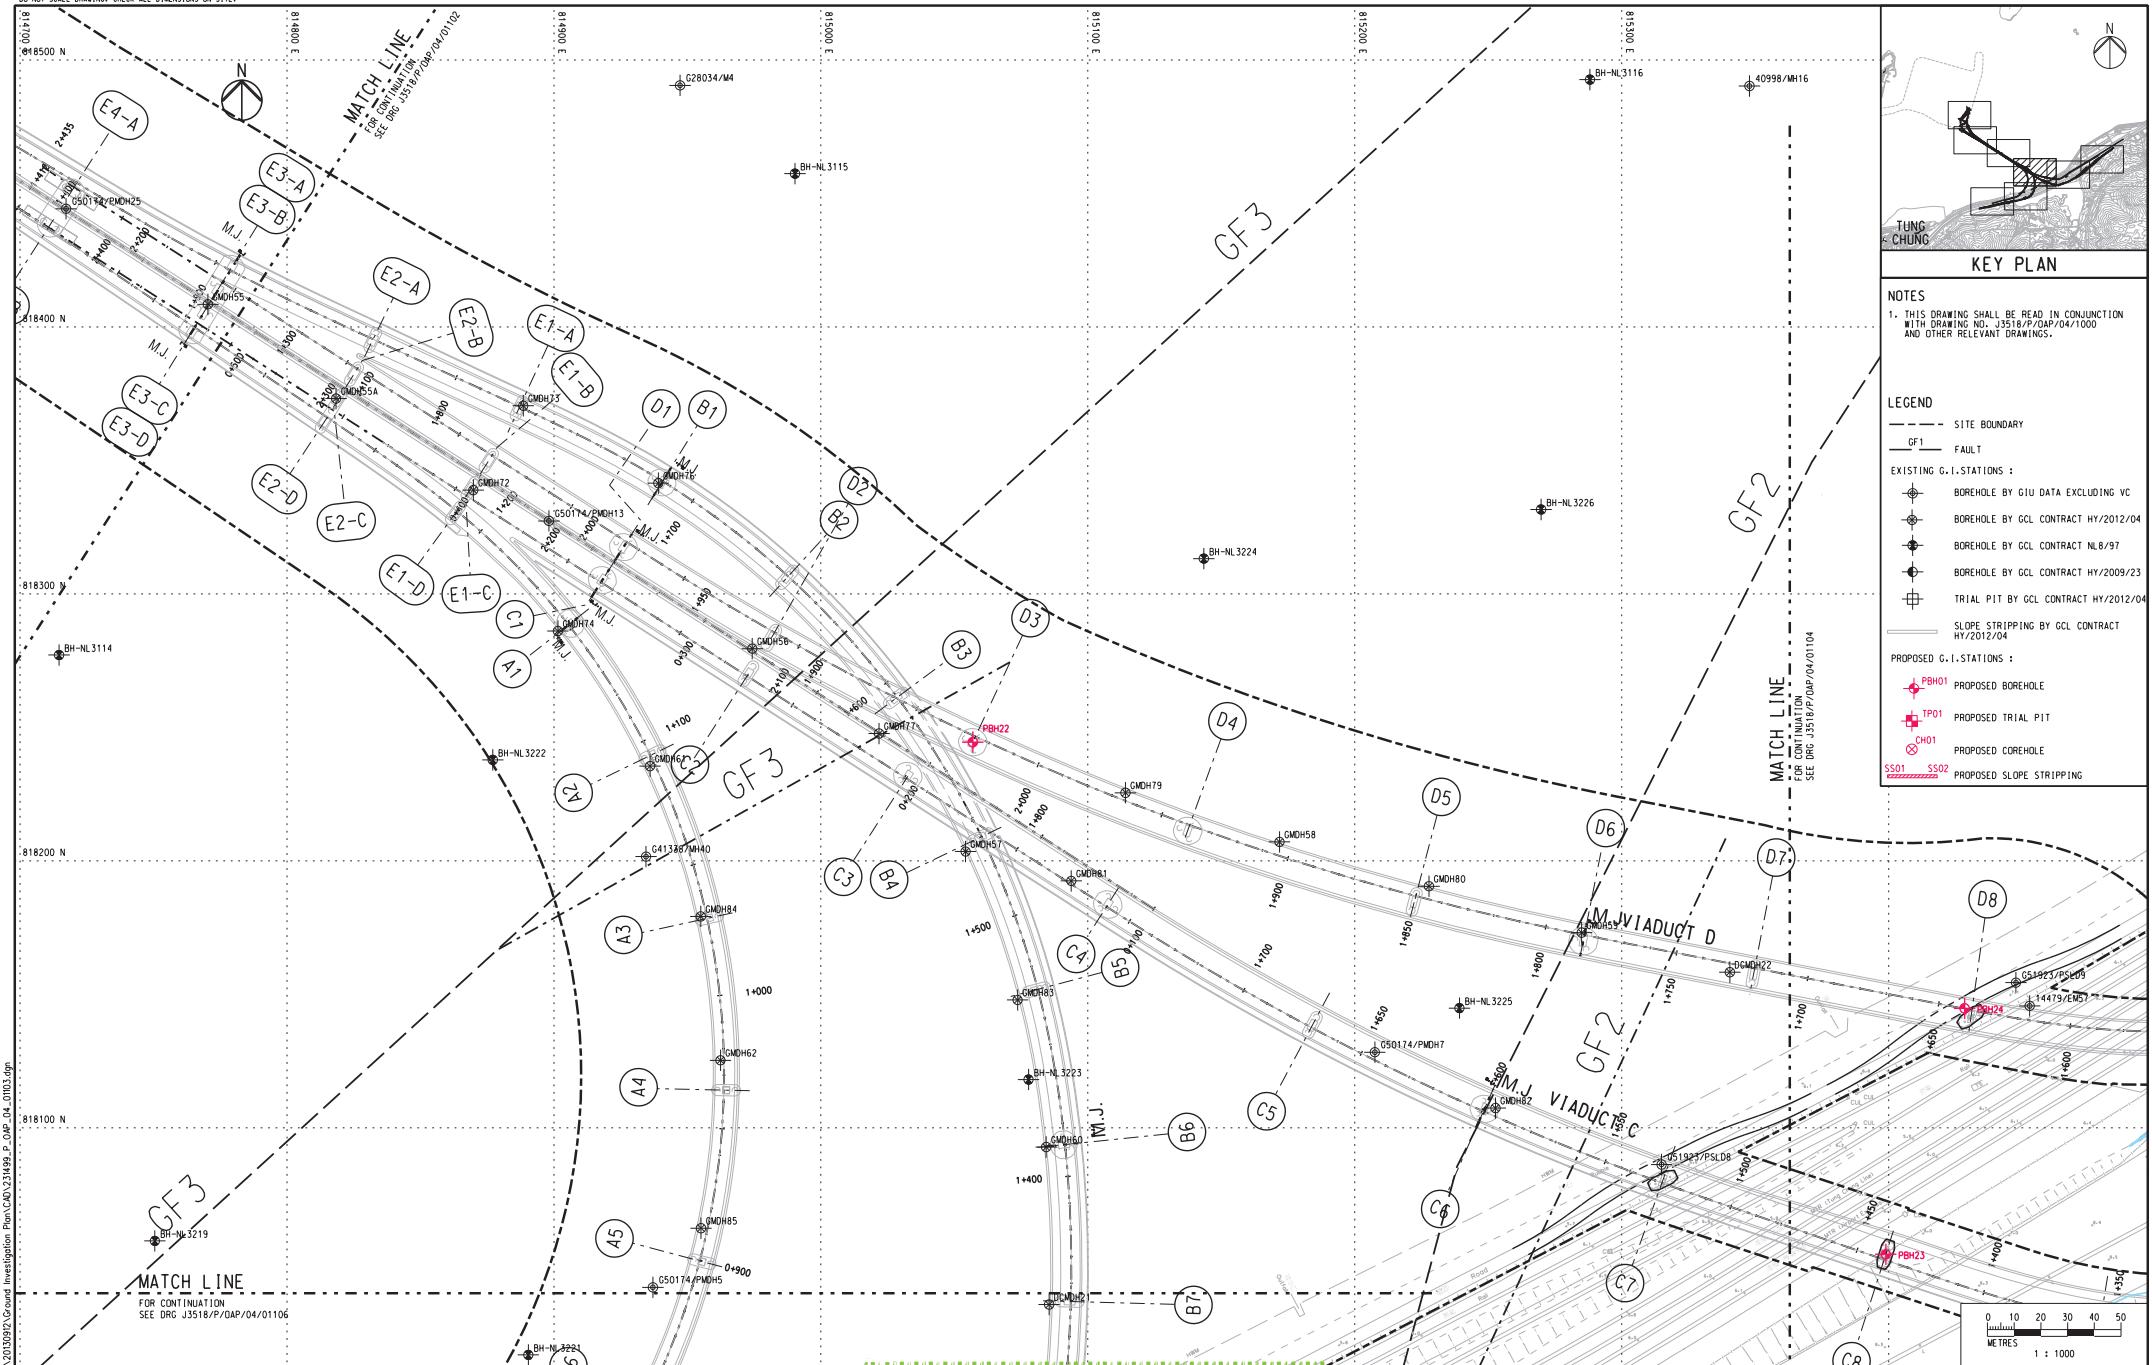


Rev	Description	By	Date	Rev	Description	By	Date
A	SUBMISSION	RC	07/13				
B	SUBMISSION	RC	07/13				
C	SUBMISSION	RC	09/13				


Drawn	Date	Client	Project Title	Drawing title
RL	07/13	路政署 HIGHWAYS DEPARTMENT Hong Kong-Zhuhai-Macao Bridge Hong Kong Project Management Office	Contract No. HY/2012/07 Tuen Mun - Chek Lap Kok Link Southern Connection Viaduct Section	
Checked	Approved			
DS	DOP			
Scale	1:1000 @ A1 / 1:2000 @ A3	Supervising Officer AECOM	Contractor Gammon	Originator ARUP

1:1000 @ A1 / 1:2000 @ A3

Figure 1.2e


Drawing no. J3518/P/OAP/04/01103 Rev. C

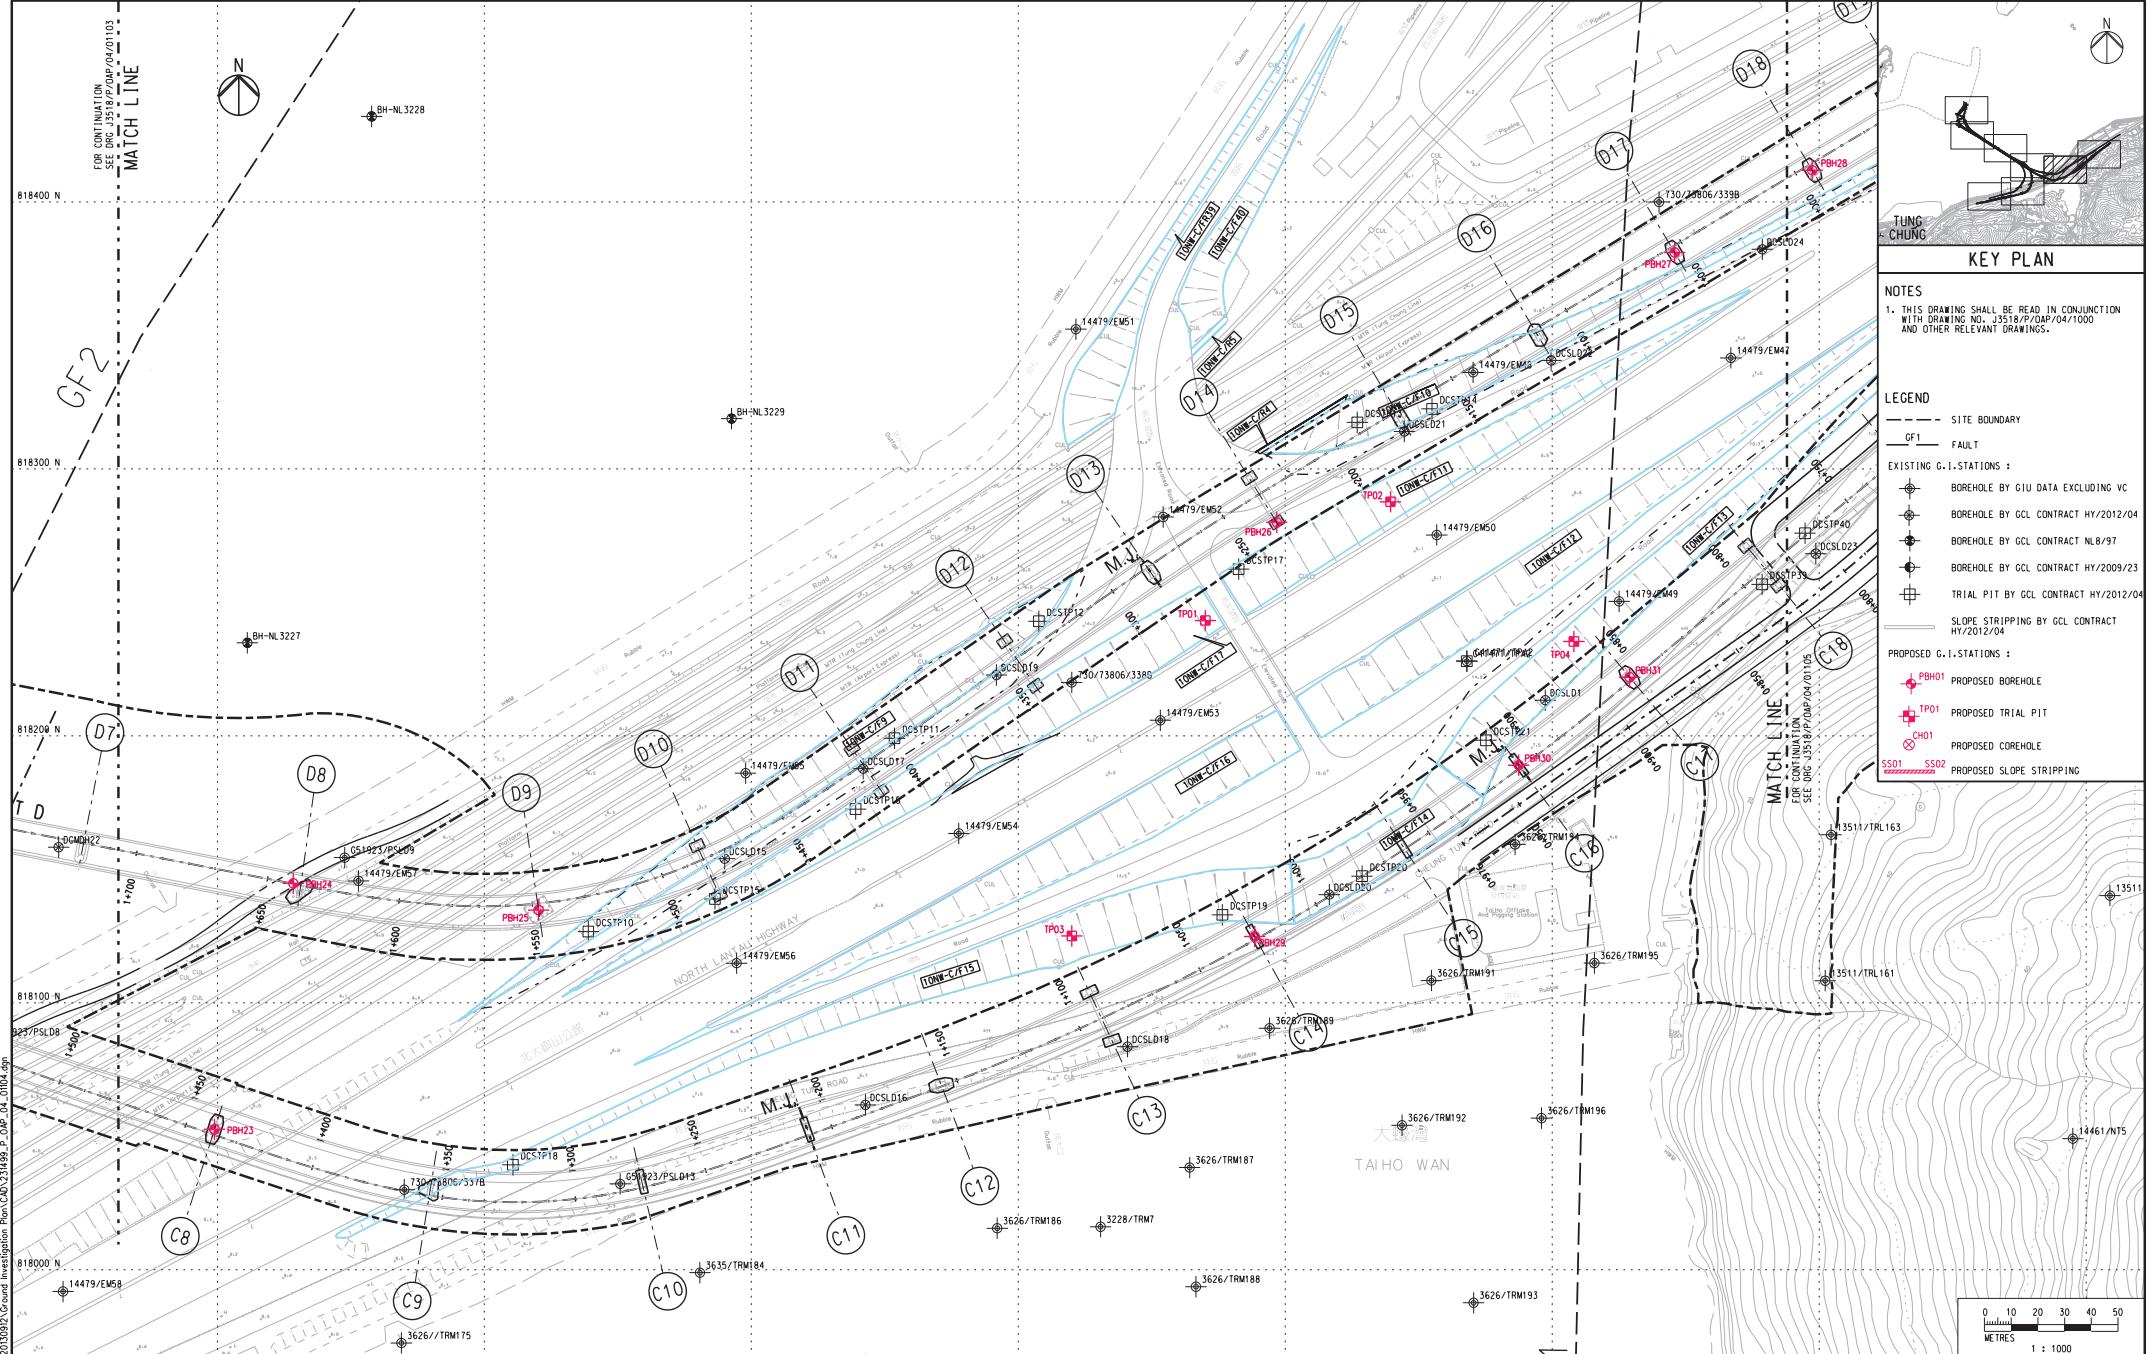

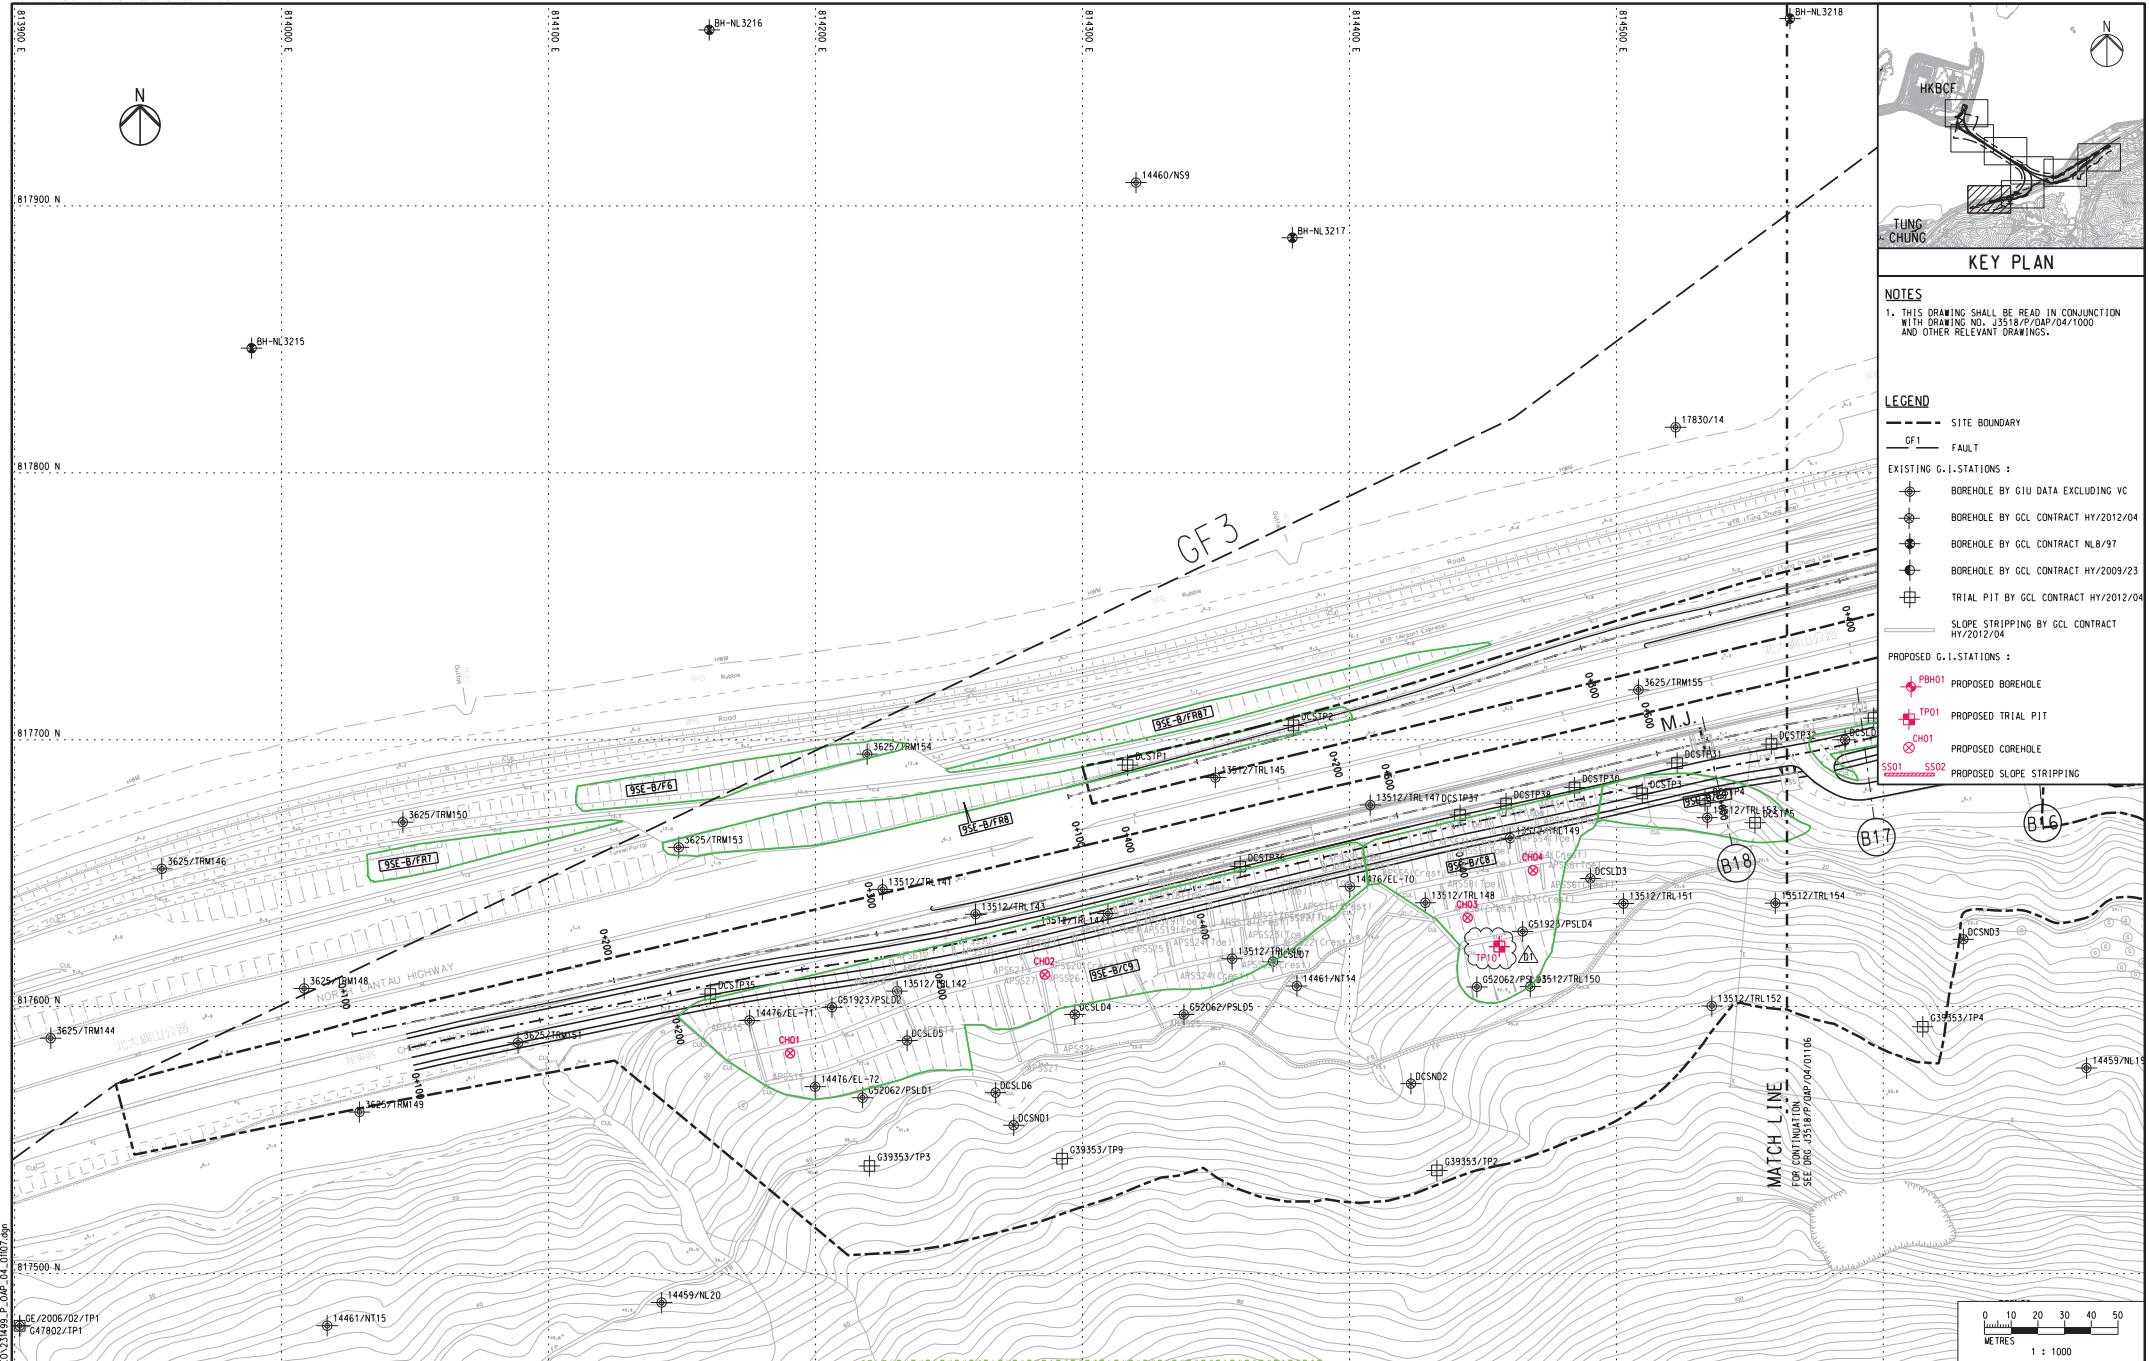

Rev	Description	By	Date	Rev	Description	By	Date
A	SUBMISSION	RC	07/13				
B	SUBMISSION	RC	07/13				
C	SUBMISSION	RC	09/13				
D1	FOR INTERNAL REVIEW	RC	11/13				

Figure 1.2g

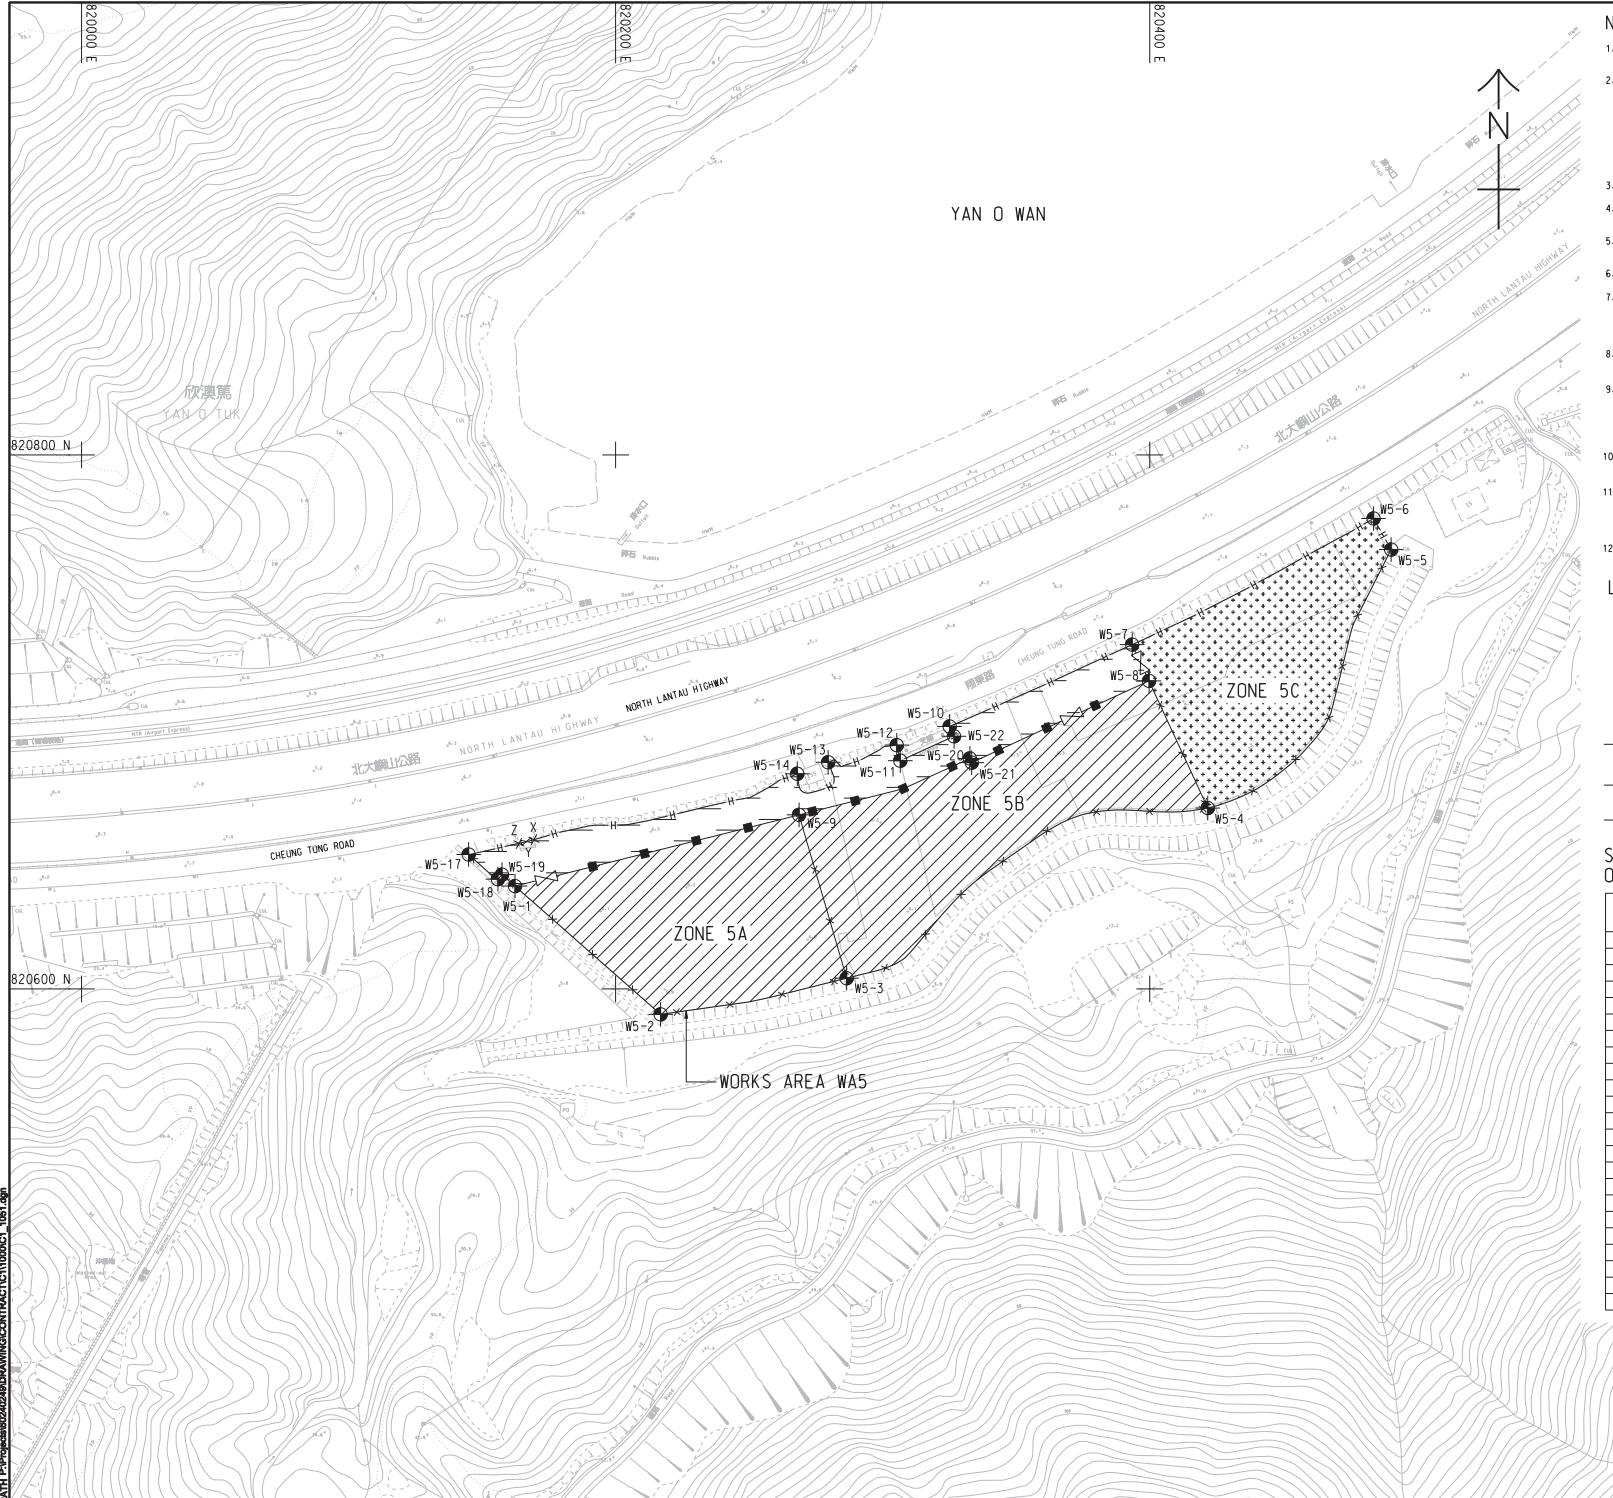

NOTES

1. THIS DRAWING SHALL BE READ IN CONJUNCTION WITH THE WORKS AREA KEY PLAN IN SHEET NO. 60420000000000000000.
 2. THE SETTING OUT INFORMATION AND WORKS AREA CONDITIONS SHOWN IN THIS DRAWING ARE FOR REFERENCE ONLY. THE WORKS AREA BOUNDARY SHALL BE DEFINED BY THE CONTRACTOR IN ENGINEERING CONDITIONS FOR TEMPORARY GOVERNMENT LAND ALLOCATION NO. TIS 619. IN CASE OF DISCREPANCY BETWEEN THE BOUNDARY SHOWN ON THIS DRAWING AND THE BOUNDARY INDICATED ON THE ENGINEERING CONDITIONS, THE LATTER SHALL PREVAIL.
 3. DEMARCACTION OF THE WORKS AREA SHALL BE DETERMINED ON SITE.
 4. REFER TO HIGHWAYS DEPARTMENT STANDARD DRAWING NO. H610 - H6111 FOR DETAILS OF HOARDING.
 5. REFER TO HIGHWAYS DEPARTMENT STANDARD DRAWING NO. H6121 AND H6122 FOR DETAILS OF CHAIN LINK FENCE.
 6. REFER TO HIGHWAYS DEPARTMENT STANDARD DRAWING NO. H6121 FOR DETAILS OF GATE.
 7. CHAIN LINK FENCE SHALL BE ERECTED ALONG THE WORKS AREA BOUNDARY. THE ALIGNMENT AND EXTENT OF THE CHAIN LINK FENCE SHOWN ARE INDICATIVE ONLY AND SHALL BE CONFIRMED BY THE SUPERVISING OFFICER.
 8. THE LOCATION AND WIDTH OF GATE SHOWN ARE INDICATIVE ONLY AND SHALL BE CONFIRMED BY THE SUPERVISING OFFICER.
 9. NO STRUCTURES SHALL BE ERECTED OTHER THAN THE STIMES NOT EXCEEDING TWO STOREYS IN HEIGHT, WHICH ARE APPROVED BY THE DISTRICT LANDS OFFICER AS BEING APPROPRIATE FOR THE USE OF THE SITE AS A WORKS AREA.
 10. THE TENTATIVE OCCUPATION PERIOD SHALL BE REFERRED TO EMPLOYER'S REQUIREMENTS PART 2 AND PART 14 SECTION 1 CLAUSE 1.45A.
 11. THE WORKS AREAS SHOWN ON THIS DRAWING ARE TO BE SHARED AMONG THE CONTRACTS OF THE CONTRACTOR. THE WORKS AREAS HATCHED WITH CROSSES ARE TENTATIVELY ALLOCATED FOR THE USE BY THIS CONTRACT.
 12. THE COMMON AREA SHALL BE CONCRETE PAVED BY THE CONTRACTOR.

AECOM

PROJECT

TUEN MUN -
CHEK LAP KOK LINK

CONTRACT

The logo consists of a stylized 'S' shape formed by two thick vertical bars with horizontal bars extending from them, followed by the text 'CLIENT' and 'SOUTHERN CONNECTION VIADUCT SECTION'.

CONSULTANT

AECOM Asia Company Ltd
www.aecom.com

SUB-CONSULTANTS

ISSUE/REVISION

POINT	COORDINATES	
	EASTING	NORTHING
W5-1	820162.308	820638.492
W5-2	820216.839	820590.455
W5-3	820286.496	820603.968
W5-4	820421.757	820667.742
W5-5	820490.425	820764.554
W5-6	820483.839	820776.180
W5-7	820393.451	820728.958
W5-8	820399.746	820715.343
W5-9	820268.674	820665.173
W5-10	820325.075	820698.274
W5-11	820306.587	820685.458
W5-12	820305.269	820691.287
W5-13	820279.580	820684.683
W5-14	820268.027	820680.572
X	820169.407	820655.859
Y	820166.601	820655.172
Z	820163.794	820654.484
W5-17	820144.957	820650.334
W5-18	820155.899	820641.093
W5-19	820157.432	820642.788
W5-20	820332.642	820666.314
W5-21	820333.350	820684.738
W5-22	820326.723	820694.508

PROJECT N

CONTRACT NO.


60240249

HY/2012/07

SHEET TITLE

WORKS A

Figure 1.2h

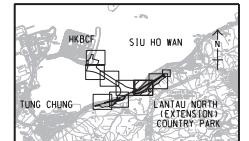


- NOTES:**
1. THIS DRAWING SHALL BE READ IN CONJUNCTION WITH THE WORKS AREA KEY PLAN IN SHEET NO. 60240249/C1/1000.
 2. THE SETTING OUT INFORMATION AND WORKS AREA CONDITIONS SHOWN IN THIS DRAWING ARE FOR REFERENCE ONLY. THE WORKS AREA BOUNDARY SHOULD BE DETERMINED ACCORDING TO THE ENGINEERING CONDITIONS FOR TEMPORARY GOVERNMENT LAND ALLOCATION NO. TIS 631.
 3. THE CONTRACTOR SHALL NOTE THAT WORKS AREA WA4 IS THE AREA FOR STORAGE OF BOXES FOR OTHER CONTRACTORS OR EMPLOYEES.
 4. THE CONTRACTOR SHALL TAKE UP AND MAINTAIN THE EXISTING CHAIN LINE FENCE AND GATE, PROVIDE THE SECURITY, SITE CLEANLINESS AND TIDINESS FOR THE WORKS AREA.
 5. THE CONTRACTOR SHALL NOTE THAT THE SETTING OUT COORDINATES OF WORKS AREA WA4 ARE TENTATIVE ONLY AND THE CONTRACTOR SHALL VERIFY THE SETTING OUT COORDINATES ON SITE.

LEGEND:

WORKS AREA WA4

EXISTING CHAIN LINK FENCE AND GATE

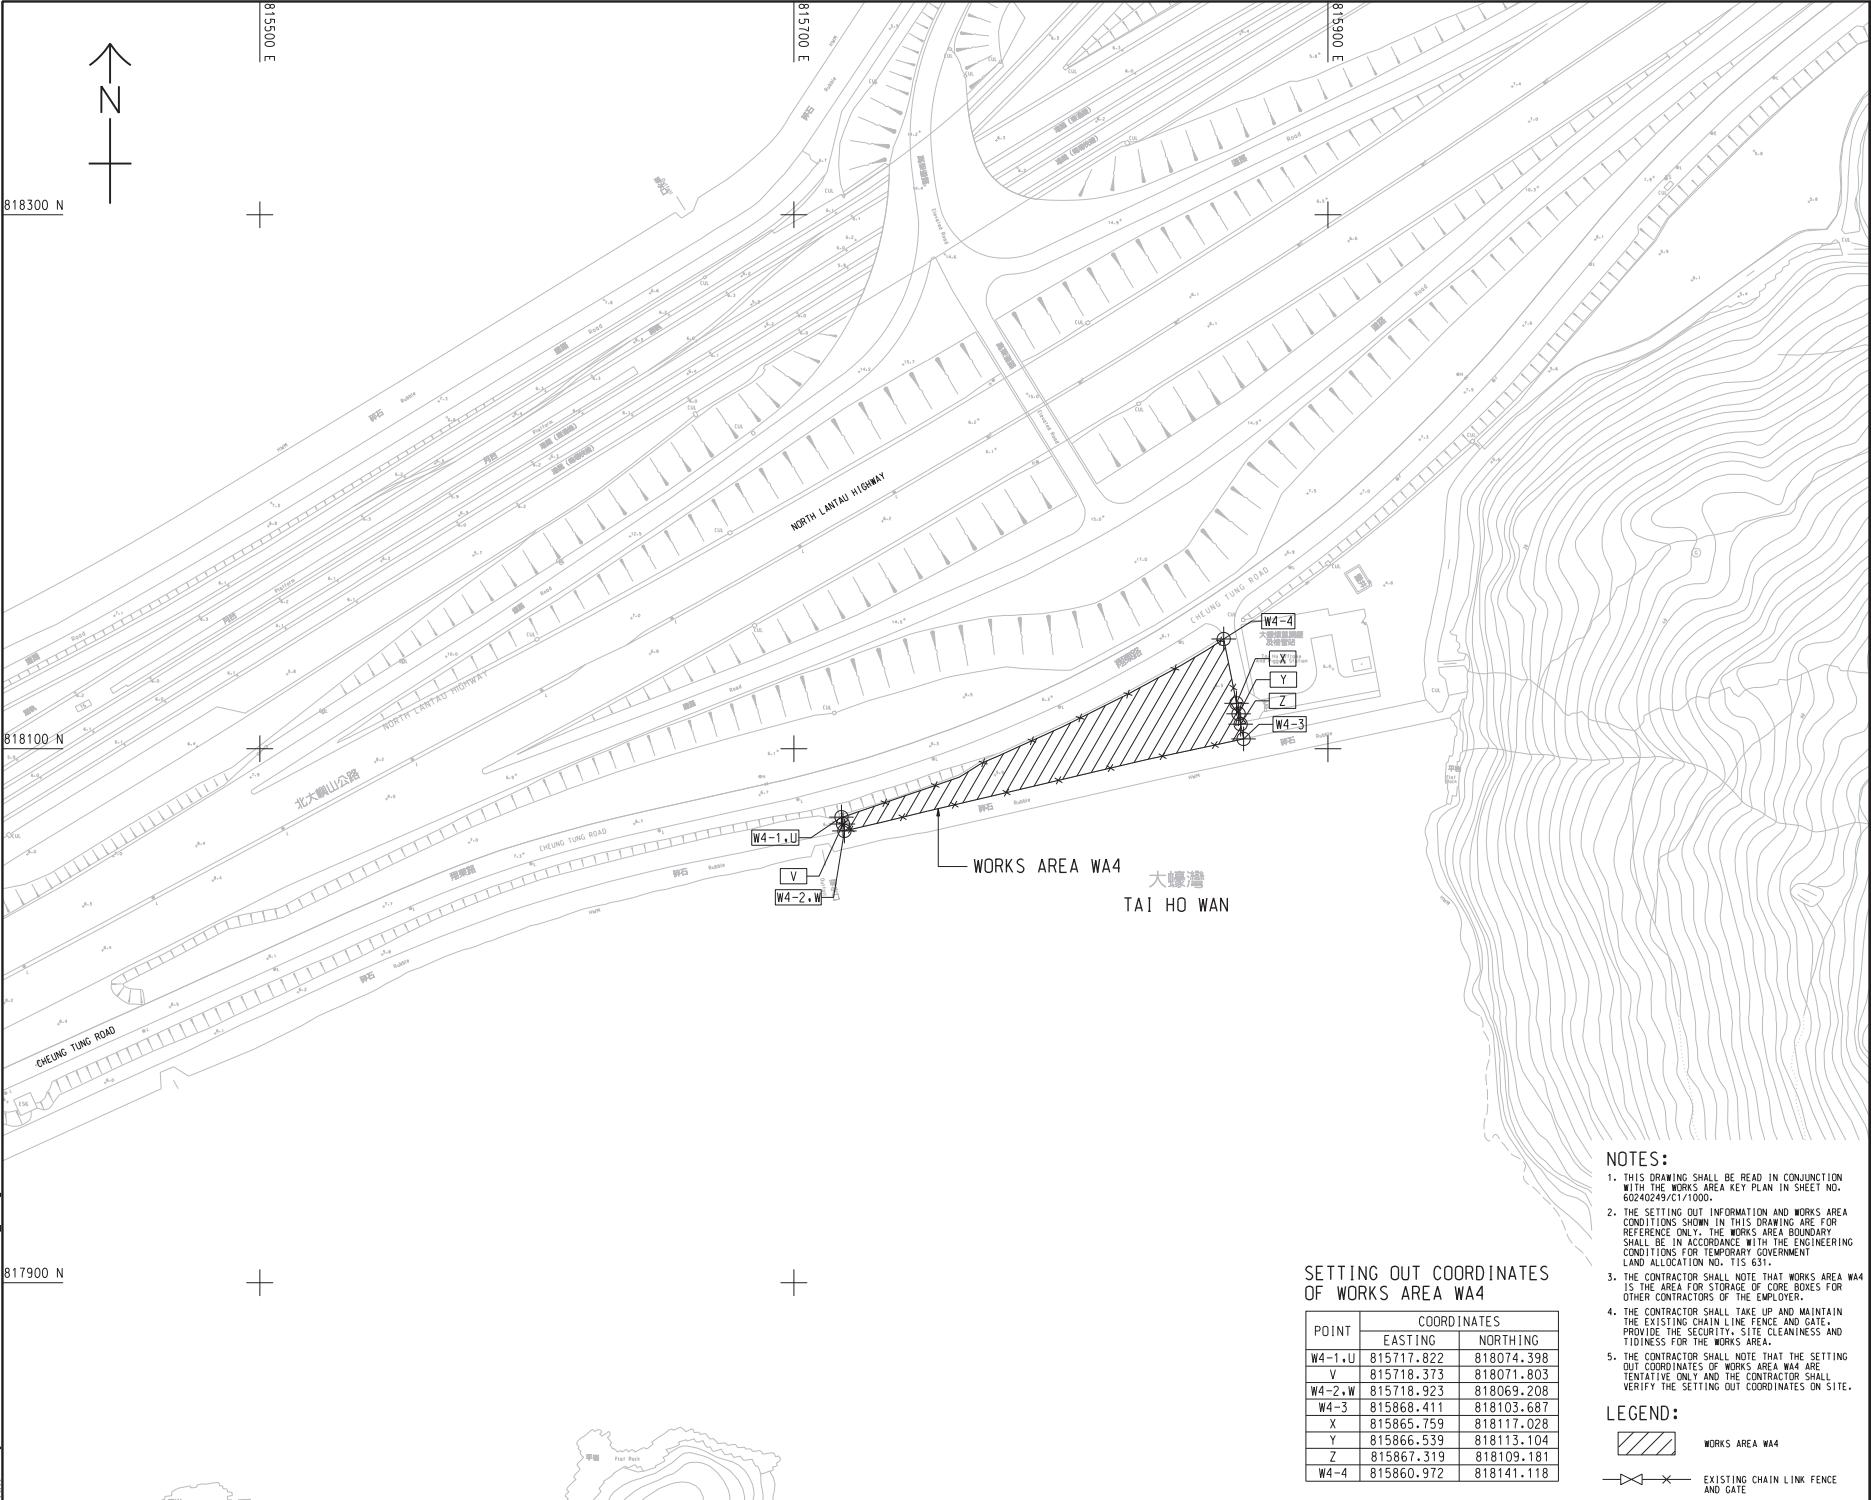

DO NOT SCALE DRAWING. CHECK ALL DIMENSIONS ON SITE.


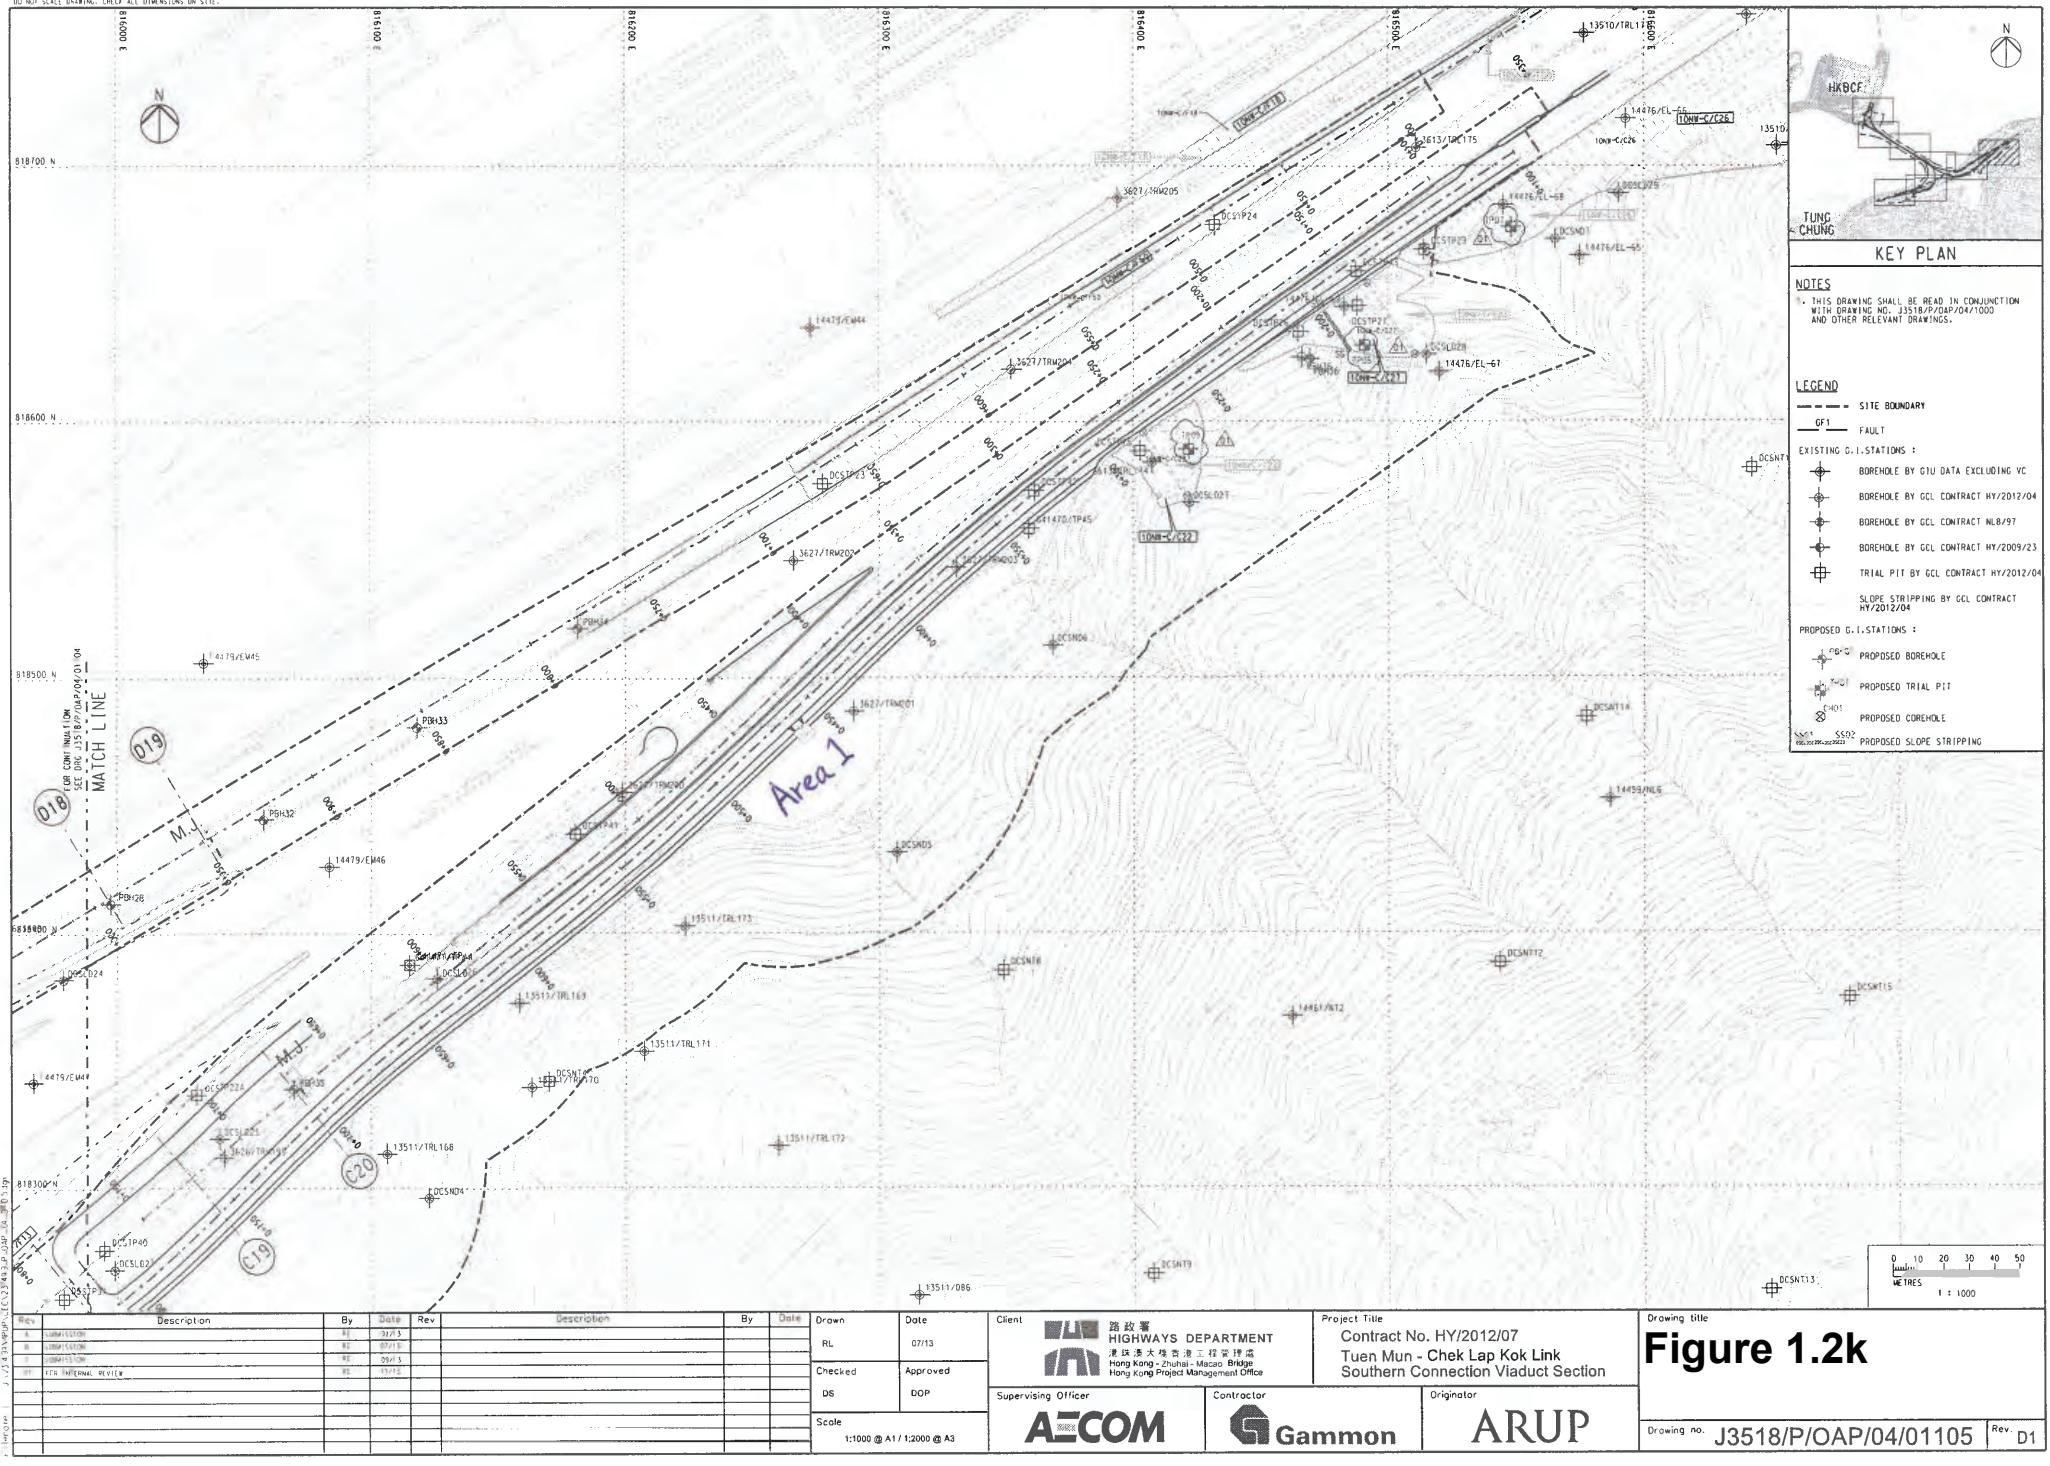


Figure 1.2k

DO NOT SCALE DRAWING. CHECK ALL DIMENSIONS ON SITE.

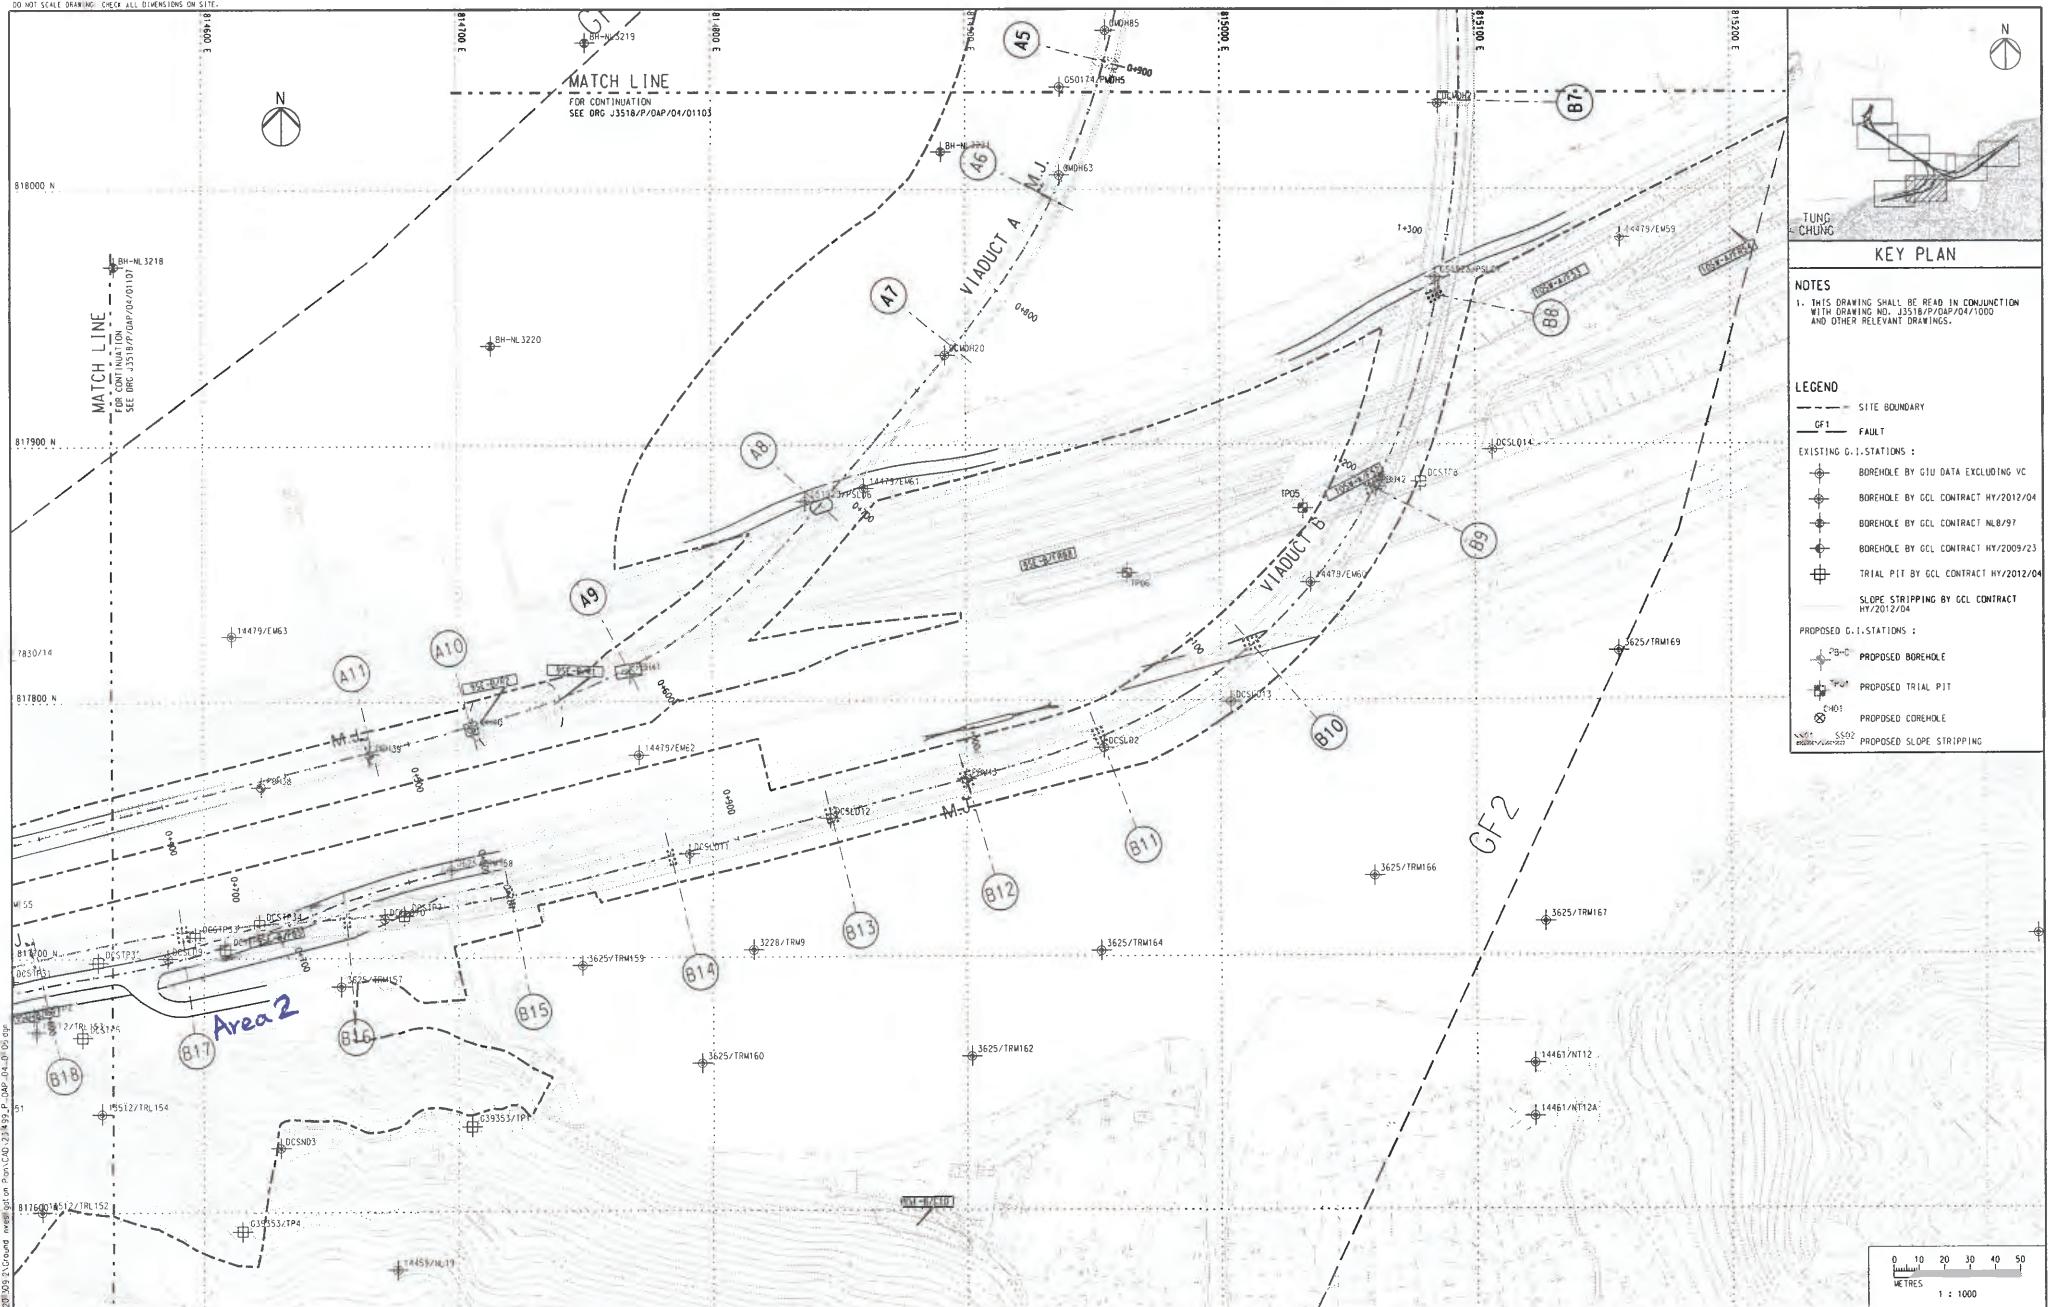

Rev	Description	By	Date	Rev	Description	By	Date	Drawn	Date
A	Initial Revision	RL	07/13					RL	07/13
B	Update Revision	RL	07/13					Checked	Approved
C	Update Revision	RL	07/13					DS	DOP
								Scce	
									1:1000 @ A1 / 1:2000 @ A3

Supervising Officer
AECOM

Contractor

originator

Drawing title

Figure 1.2I

Drawing no. J3518/P/QAP/04/01106 Rev. C